BH 164 4963 Rae Lane

- 2 story slab
- 1 large tankless heater
- 2 Hose bibs no valves required
- 1 tiled shower
- 2 tubs

Irrigation system

Laundry Tub in washer room

Ice maker

Humidifier valve

Gas Furnace, Tankless Heater, Range and Courtyard firepit



BH 164

MASTER PLAN: Promenade Plus | ELEVATION: Elevation B | COMMUNITY: Bel Haven | LOT NUMBER: | CUSTOMER: 4963 Rae Lane, West Chester, Ohio 45069

PLANS POWERED BY HIGHARC

PROJECT SUMMARY	
BUILDING AREA	
CONDITIONED AREA	
FIRST FLOOR SF	2122 SF
SECOND FLOOR SF	812 SF
TOTAL CONDITIONED AREA :	2865 SF
TOTAL GARAGE AREA :	493 SF
FRONT PORCH AND PORTICO AREA :	176 SF
REAR PORCH AREA :	488 SF
PATIO AREA:	199 SF

GENERAL NOTES
ONLY LOCATION SPECIFIC OPTIONS ARE SHOWN ON THESE DRAWINGS. PLEASE REFER TO OPTION SUMMARY AND/OR PURCHASE ORDERS FOR A COMPLETE LISTING OF OPTIONS.
DESIGN CRITERIA:
NUMBER OF STORIES: 2
BUILDING WIDTH: 42'-3"
BUILDING DEPTH: 77'-7"
BUILDING HEIGHT: 23'-4 1/2"
GOVERNMENTAL CODES AND STANDARDS
HOME TO BE BUILT TO CONFORM TO ALL APPLICABLE LOCAL CODES, PRACTICES AND STANDARDS.
BUILDING CODE ANALYSIS / DESIGN CRITERIA
HOME TO BE BUILOT TO 2019 RESIDENTIAL CODE OF OHIO STANDARDS

GRAPHIC SYMBOLS & LEGEND	
FIRST FLOOR EL. 0'-0"	ELEVATION MARKER
SLOPE 4:12	ROOF SLOPE
⊚	SD
sico	SD/CO

COVER	A-000
SCHEDULES	A-010
GENERAL NOTES	A-020
FOUNDATION PLAN	A-050
FIRST FLOOR PLAN	A-101
SECOND FLOOR PLAN	A-102
ROOF PLAN	A-120
FRONT / BACK ELEVATION	A-200
LEFT / RIGHT ELEVATION	A-201
DETAILS	A-401
DETAILS	A-402
DETAILS	A-403
DETAILS	A-404
DETAILS	A-405
PERSPECTIVE VIEWS	A-900
FIRST FLOOR ELECTRICAL PLAN	E-101
SECOND FLOOR ELECTRICAL PLAN	E-102
SHEAR WALL PLAN	S-100
SHEAR WALL DETAILS	S-101

EPCON® COMMUNITIES

Epcon Foundation DG

Bel Haven LLC West Chester, OH.

Higharc, Inc. is not an architectural firm nor are the artistic representations contained herein intended to be construed as ready-to-use architectural plans, construction documents, drawings, renderings, or any other similar or related documents. All drawings are artist's representations only and solely intended to reflect design intent derived exclusively from the home building plans and associated information, data, and specifications provided by Epcon Foundation DG. Higharc, Inc. is not responsible, nor may it be held liable for any errors or omissions contained herein or resulting from its usage. Any usage of the representations should be reviewed by local professionals to ensure conformance with local and state codes and be field verified prior to the start of any construction.


PROJECT	
PLAN: BH Promenade Plus D4	
ELEV: Elevation B	
LOT: 164	
DRAWING TITLE	
COVER	
SHEET NUMBER	
A-000	
7-000	

© 2025 HIGHARC, INC

ISSUE DESCRIPTION

01 BUILDER SET

10/20/2025

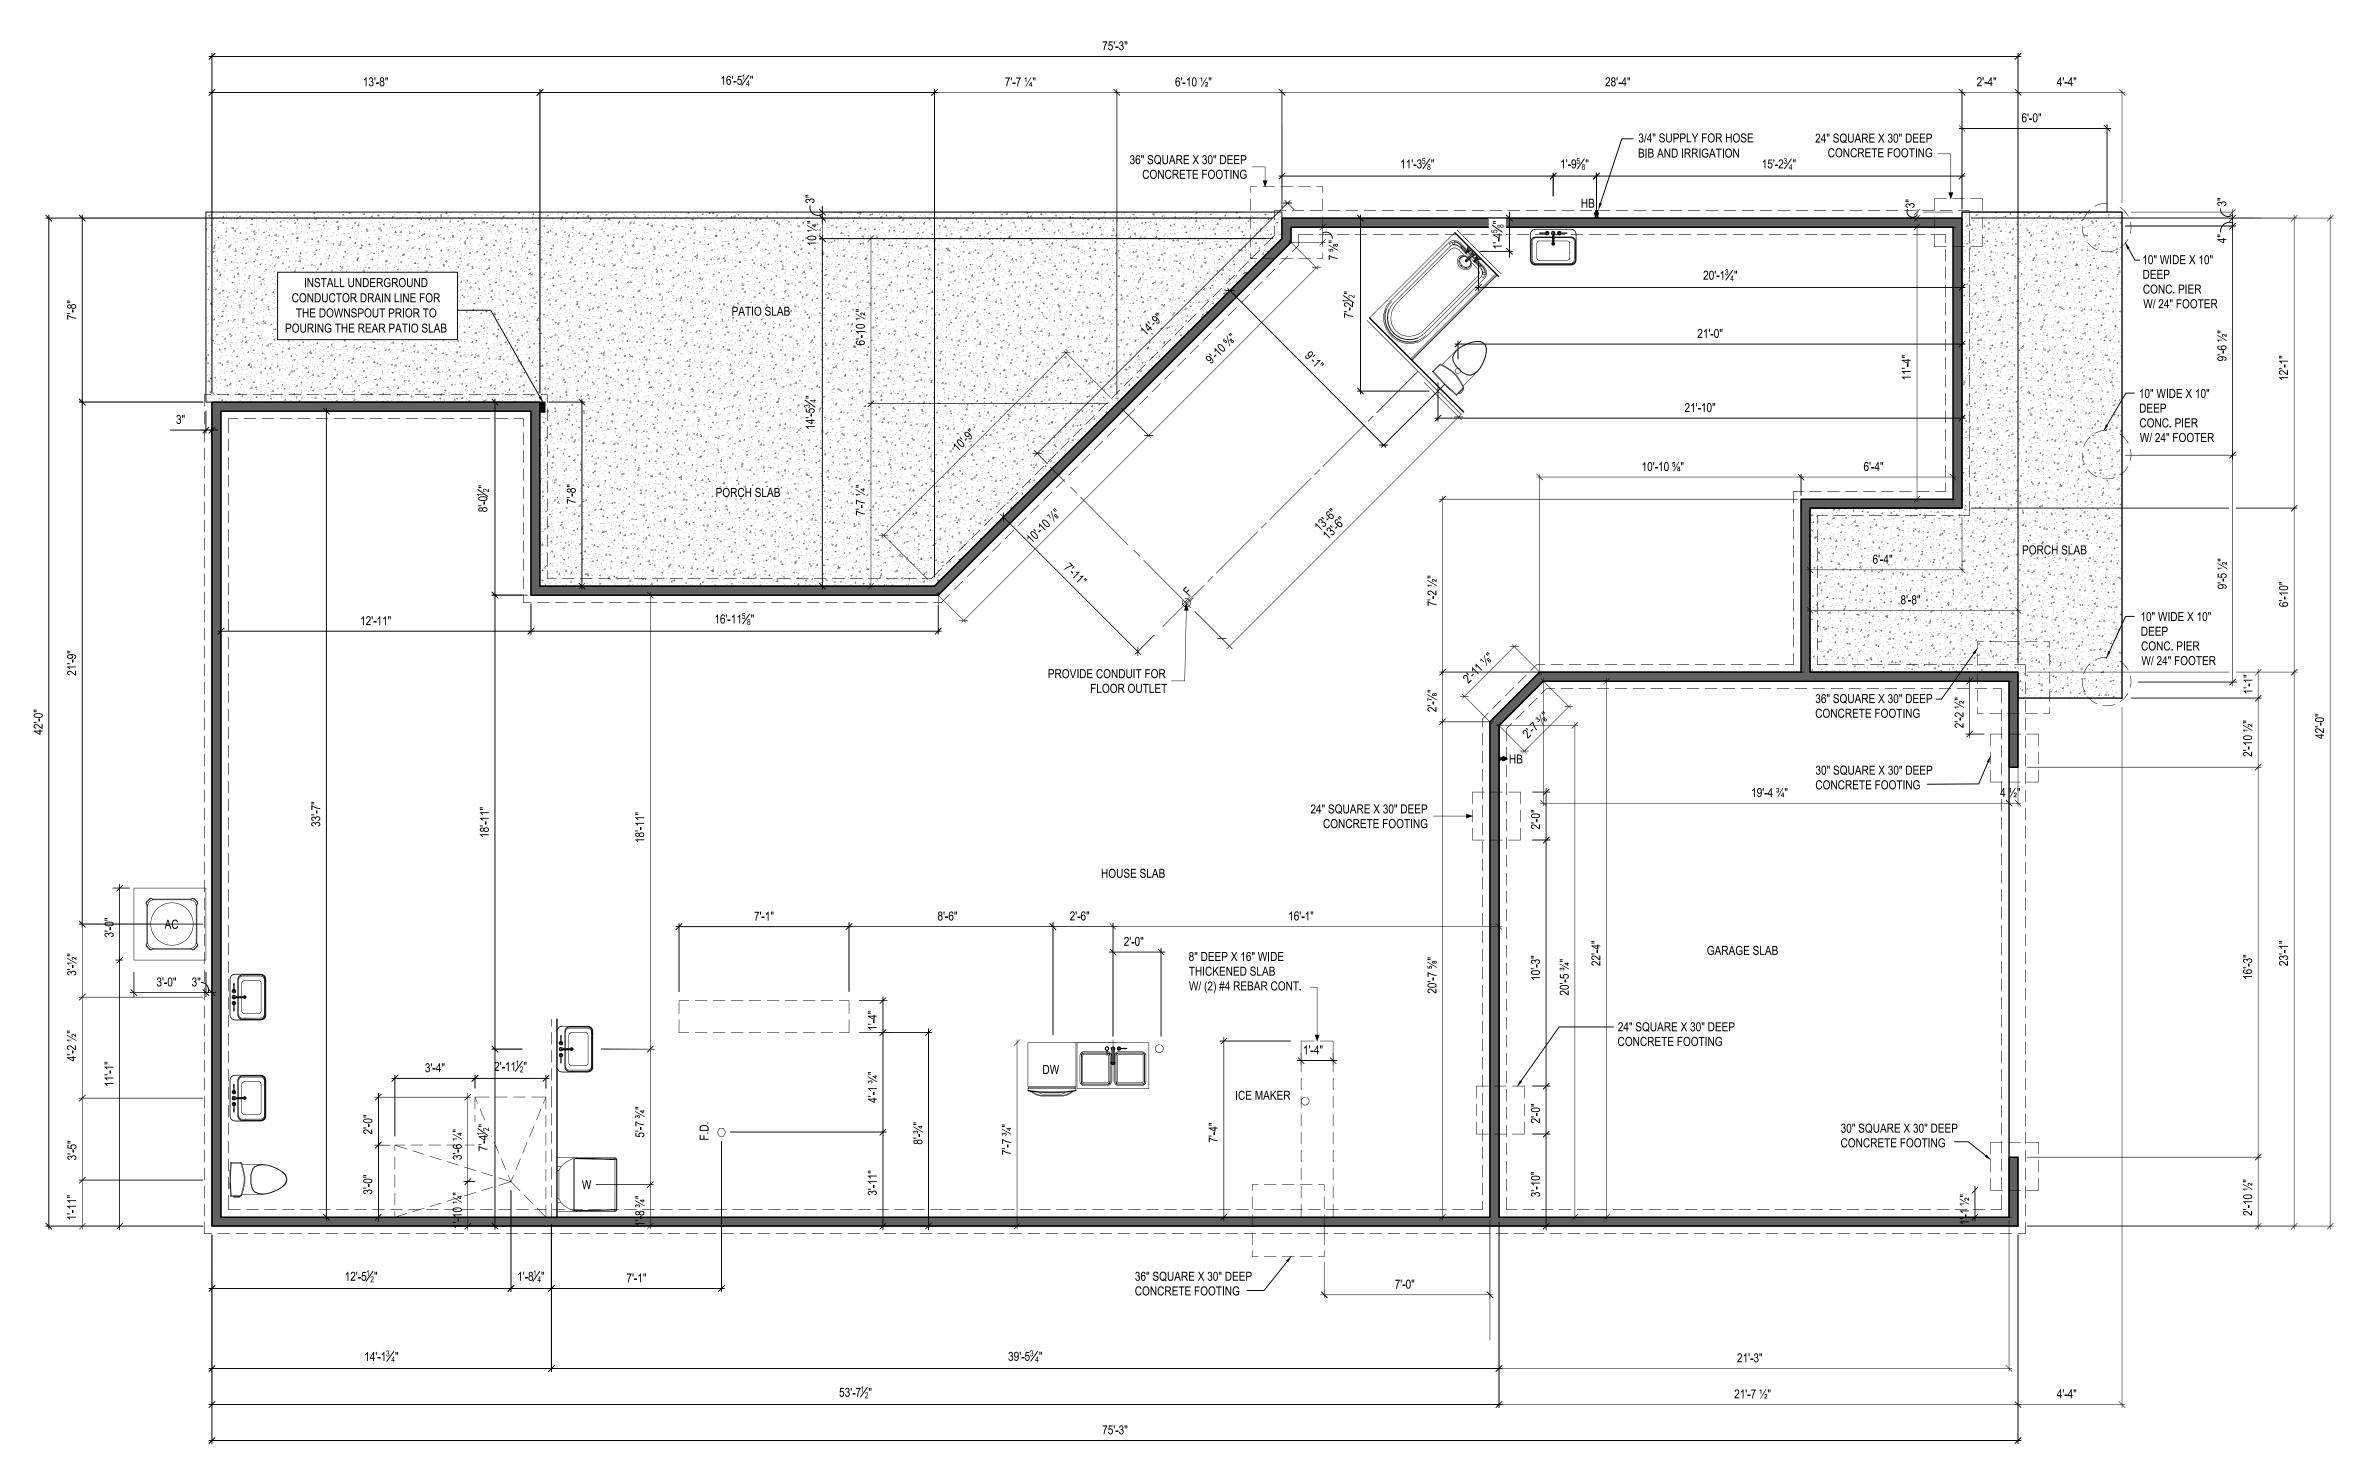

NOTES: THICKENED SLAB SHALL BE REINFORCED WITH CONTINUOUS (2) #4 REBAR



FOUNDATION PLAN

1/8" = 1'-0" @ 11" x 17"



Epcon Foundation DG

Bel Haven LLC

West Chester, OH.

Higharc, Inc. is not an architectural firm nor are the artistic representations contained herein intended to be construed as ready-to-use architectural plans, construction documents, drawings, renderings, or any other similar or related documents. All drawings are artist's representations only and solely intended to reflect design intent derived exclusively from the home building plans and associated information, data, and specifications provided by Epcon Foundation DG. Higharc, Inc. is not responsible, nor may it be held liable for any errors or omissions contained herein or resulting from its usage. Any usage of the representations should be reviewed by local professionals to ensure conformance with local and state

codes and be field verified prior to the start of any construction.

ISSUE	DESCRIPTION	DATE
01	BUILDER SET	8/19/2025

PROJECT

PLAN: BH Promenade Plus D4
ELEV: Elevation B

LOT: 169

DRAWING TITLE

FOUNDATION PLAN

SHEET NUMBER

A-05

© 2025 HIGHARC, INC

- NOTES:

 1.) ARCHED OPENINGS: SPRING POINT @ 7'8"

 A.A. T. TOP OF ARCH 8'-6" ABOVE SPRING
- POINT.

 2.) WINDOWS R.O. HEAD HEIGHT TO BE 8'-0" A.F.F. U.N.O.

 3.) DISTANCE BETWEEN GROUPED WINDOWS SHALL BE 4-1/2".



Epcon Foundation DG

Bel Haven LLC West Chester, OH.

Higharc, Inc. is not an architectural firm nor are the artistic representations contained herein intended to be construed as readyto-use architectural plans, construction documents, drawings, renderings, or any other similar or related documents. All drawings are artist's representations only and solely intended to reflect design intent derived exclusively from the home building plans and associated information, data, and specifications provided by Epcon Foundation DG. Higharc, Inc. is not responsible, nor may it be held liable for any errors or omissions contained herein or resulting from its usage. Any usage of the representations should be reviewed by local professionals to ensure conformance with local and state codes and be field verified prior to the start of any construction.

ISSUE	DESCRIPTION	DATE
01	BUILDER SET	10/20/2025

PLAN: BH Promenade Plus D4 ELEV: Elevation B

LOT: 164


DRAWING TITLE

FIRST FLOOR PLAN

SHEET NUMBER

A-101

© 2025 HIGHARC, INC

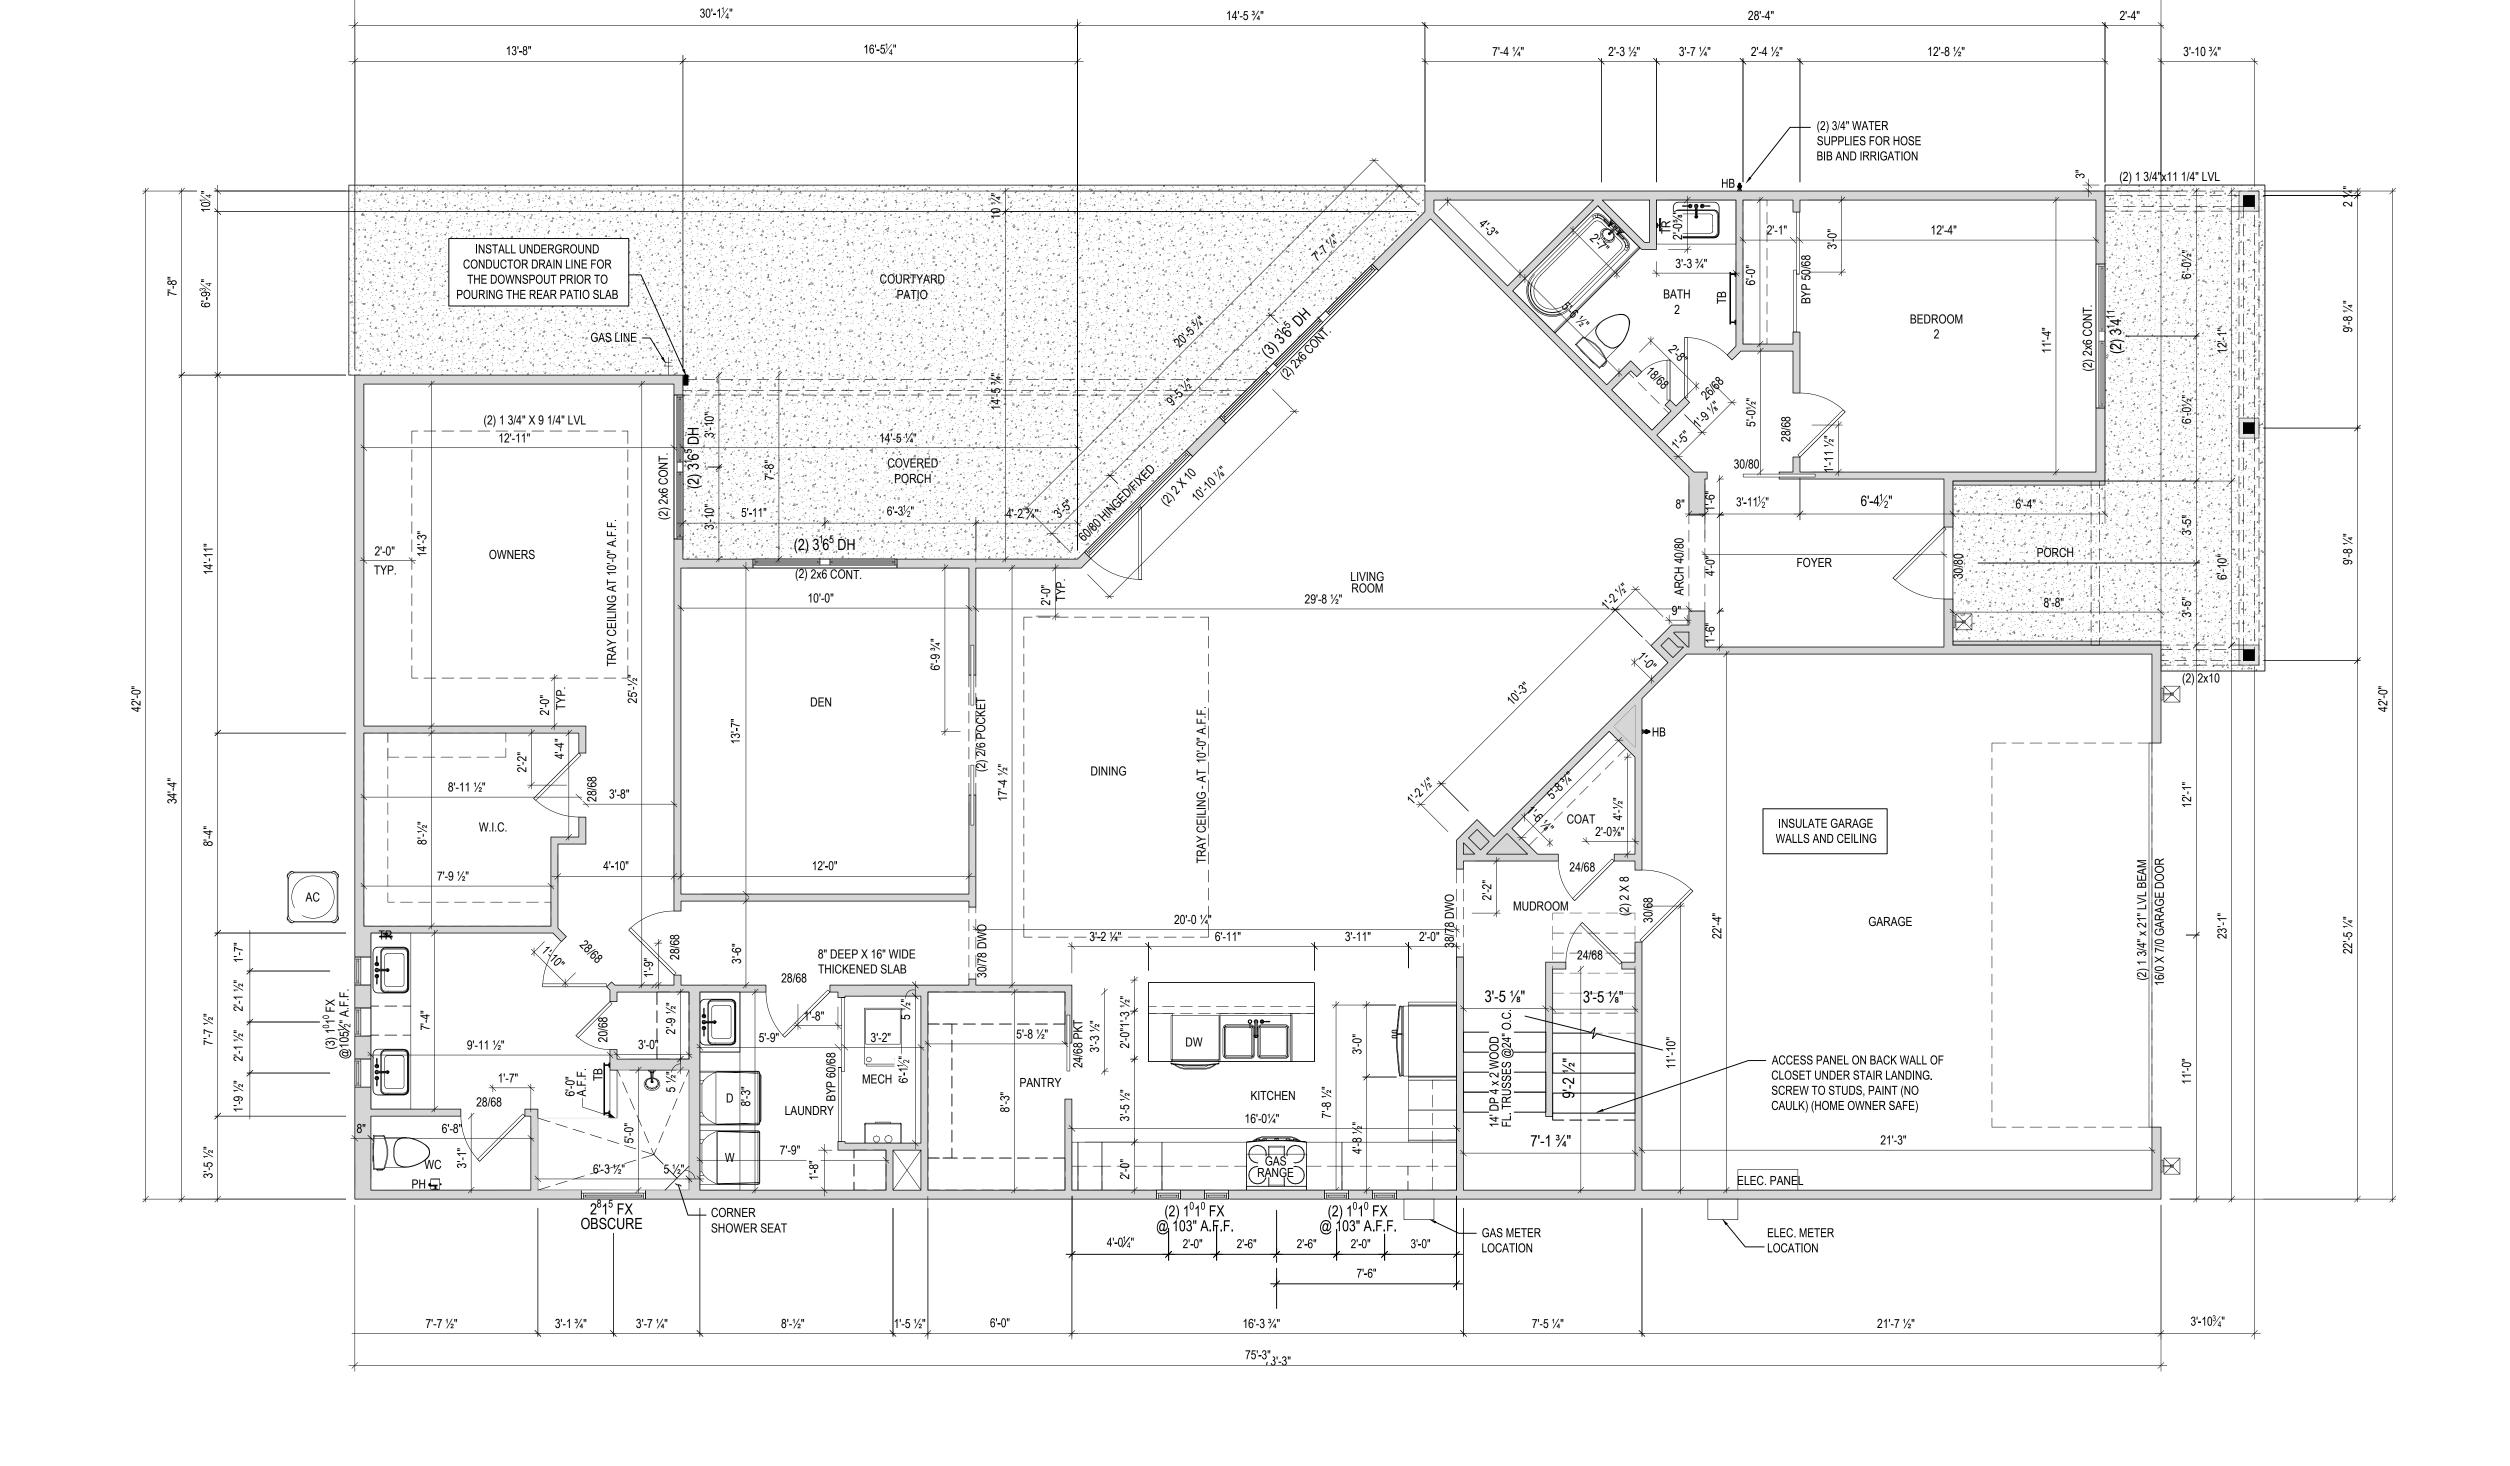


75'-3"



FLOOR PLAN

1/8" = 1'-0" @ 11" x 17"

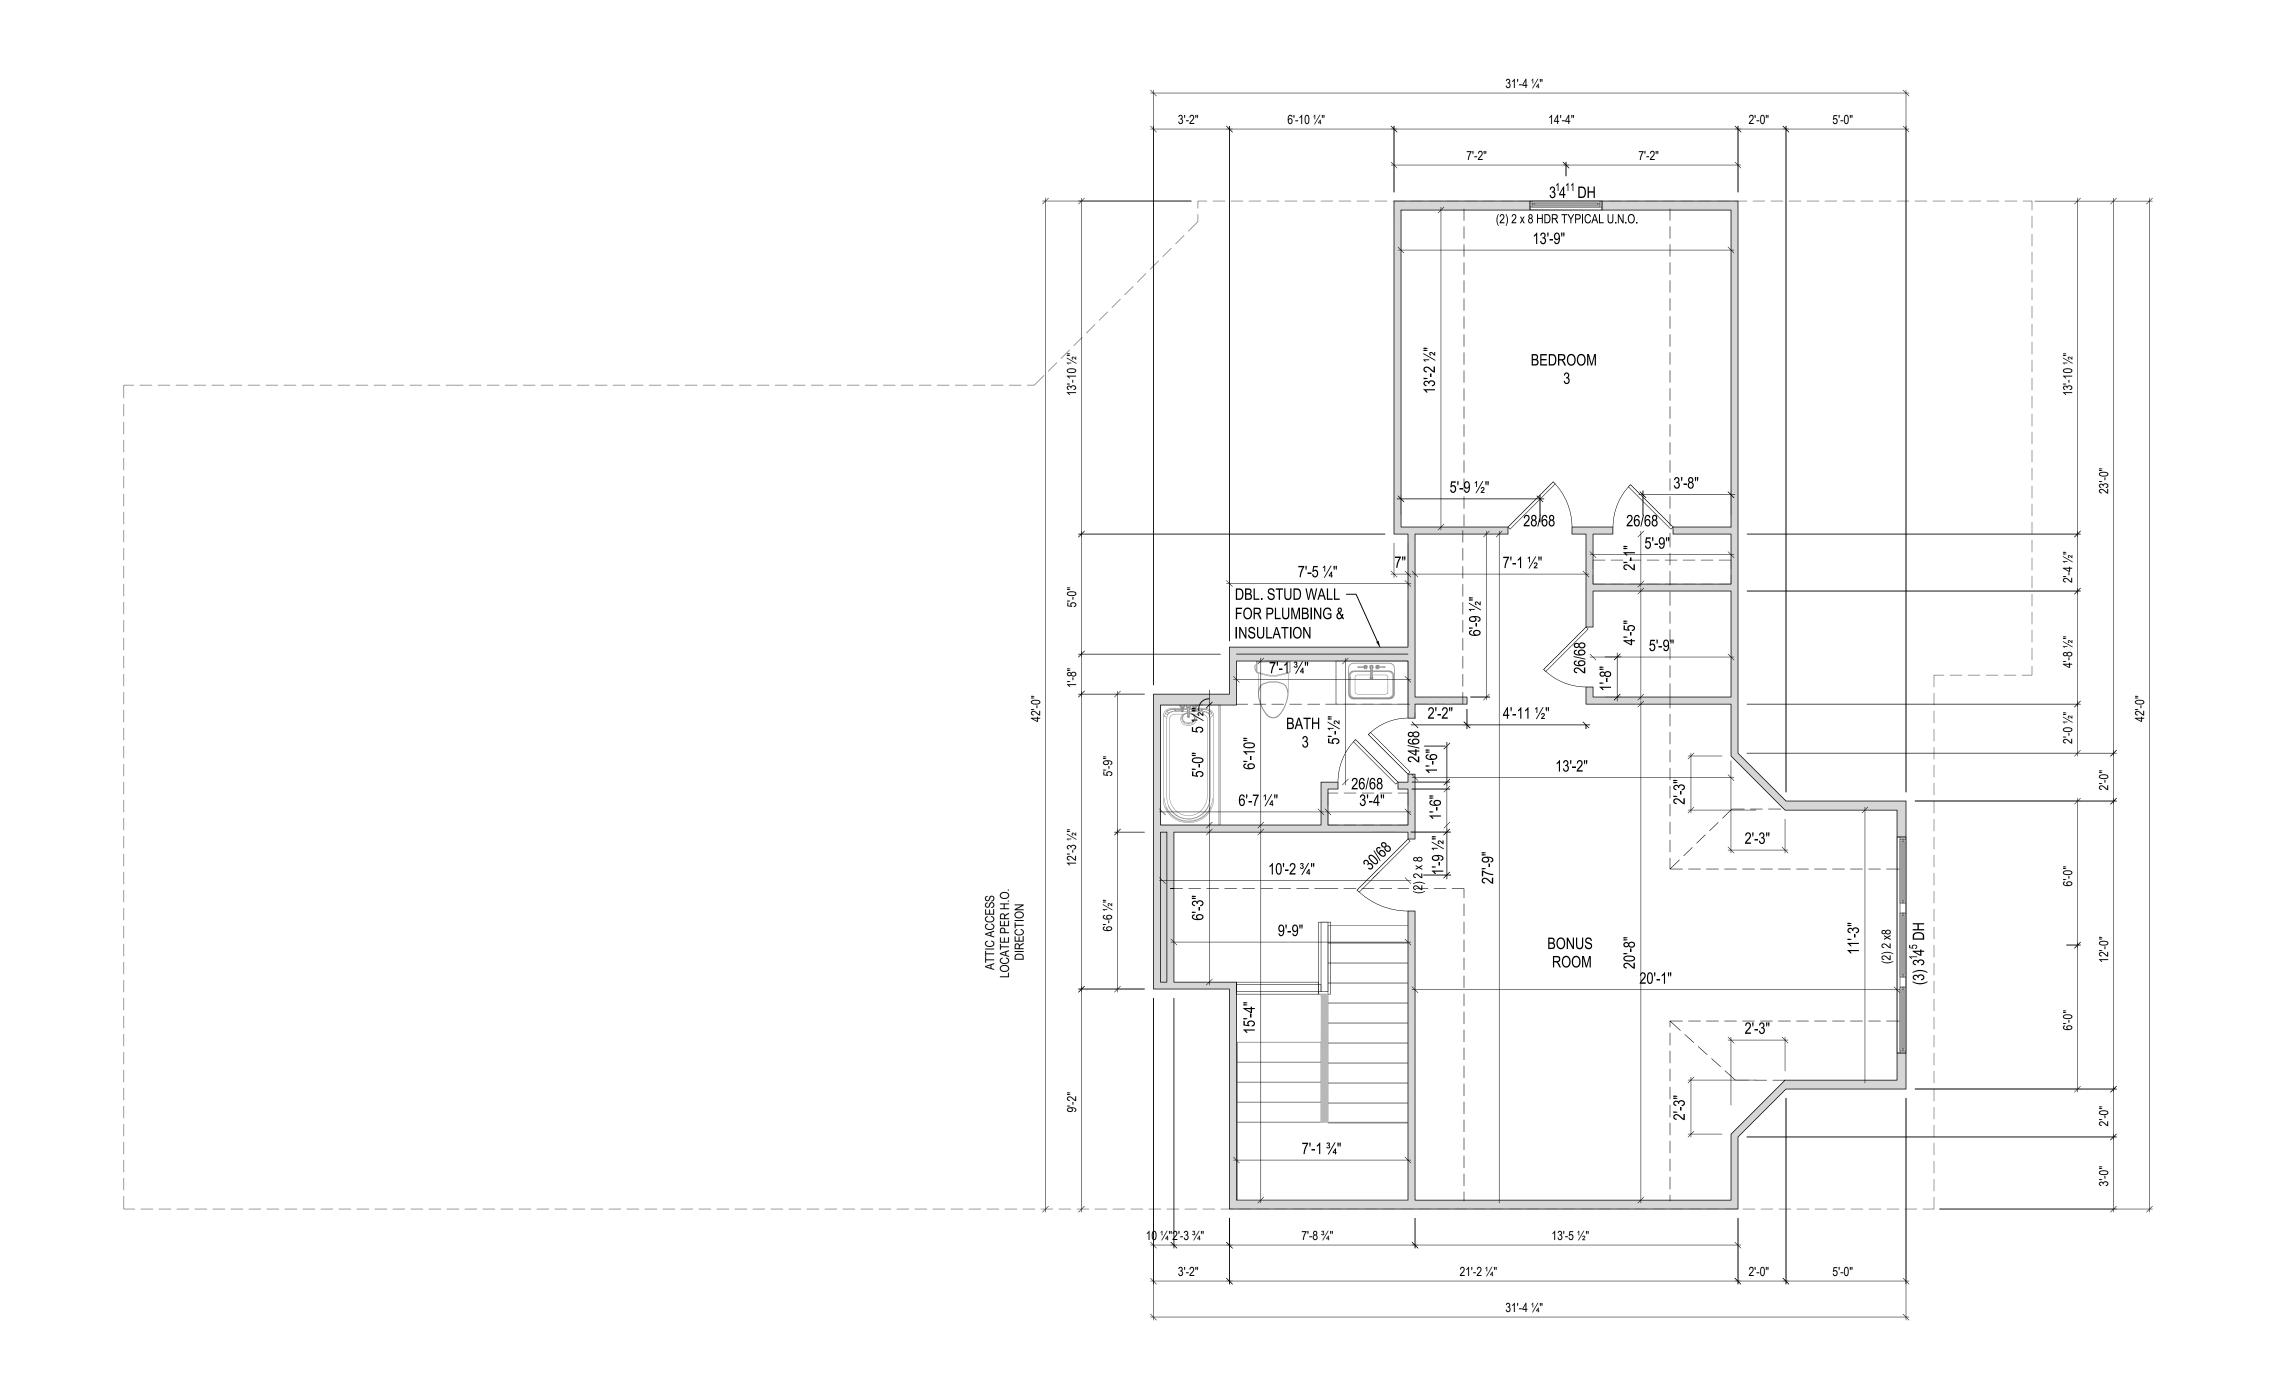



Epcon Foundation DG

Bel Haven LLC West Chester, OH.

Higharc, Inc. is not an architectural firm nor are the artistic representations contained herein intended to be construed as ready-to-use architectural plans, construction documents, drawings, renderings, or any other similar or related documents. All drawings are artist's representations only and solely intended to reflect design intent derived exclusively from the home building plans and associated information, data, and specifications provided by Epcon Foundation DG. Higharc, Inc. is not responsible, nor may it be held liable for any errors or omissions contained herein or resulting from its usage. Any usage of the representations should be reviewed by local professionals to ensure conformance with local and state codes and be field verified prior to the start of any construction.

ISSUE	DESCRIPTION	DATE
01	BUILDER SET	10/20/2025

PROJECT

PLAN: BH Promenade Plus D4
ELEV: Elevation B

LOT: 164

DRAWING TITLE

SECOND FLOOR PLAN

SHEET NUMBER


A-102

© 2025 HIGHARC, INC

1 A-102


1/8" = 1'-0" @ 11" x 17"

FLOOR PLAN

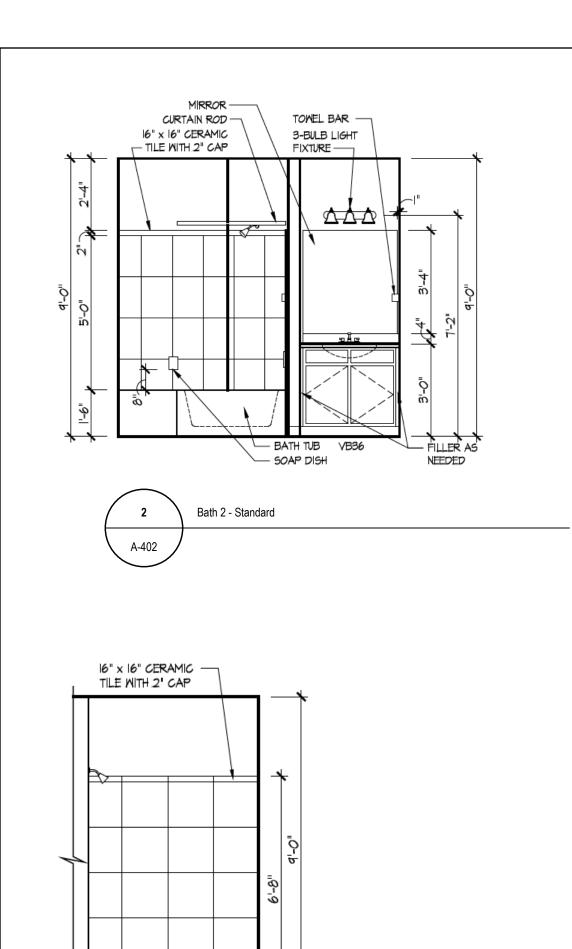

Master Bath Shower - Walk-in

A-402

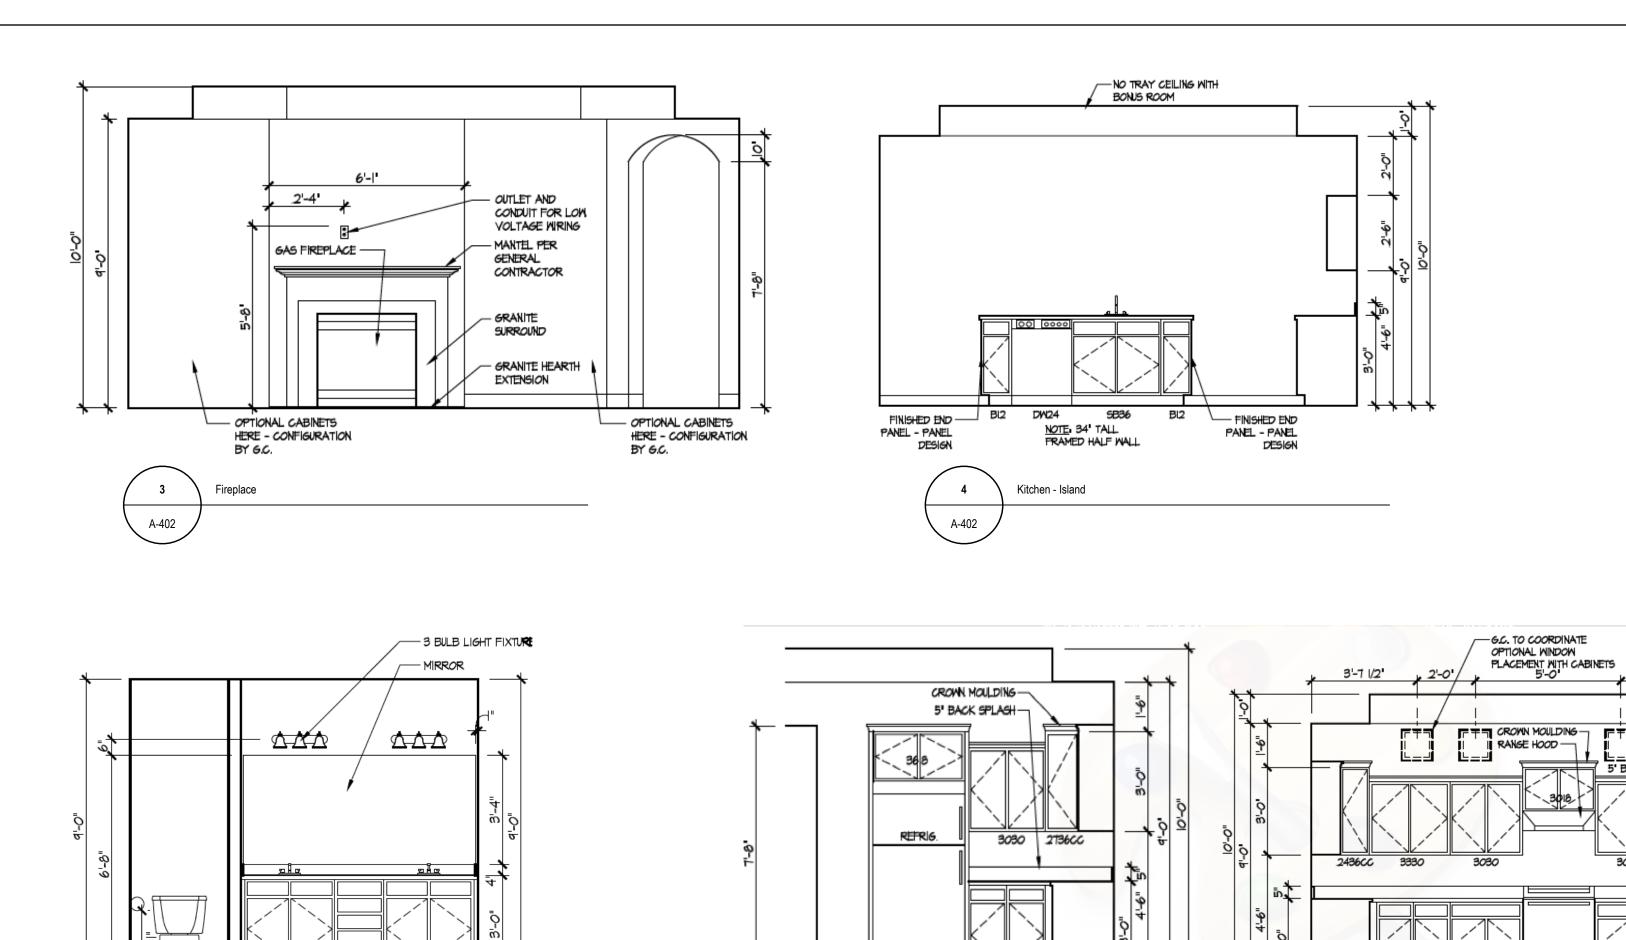

Kitchen Staggered Layout

FILLER

Master Bath Vanity

A-402



FILLER ______ BCB42 BI5 B30

01	BUILDER SET	10/20/2025
PROJECT		
PLAN: BH Promer	nade Plus D4	
ELEV: Elevation B	}	
LOT: 164		
201. 101		
DRAWING TITLE		
DETAILS		

SHEET NUMBER

© 2025 HIGHARC, INC

A-402

ISSUE DESCRIPTION

Epcon Foundation DG

Bel Haven LLC West Chester, OH.

Higharc, Inc. is not an architectural firm nor are the artistic representations contained herein intended to be construed as ready-to-

use architectural plans, construction documents, drawings, renderings,

representations only and solely intended to reflect design intent derived exclusively from the home building plans and associated information,

omissions contained herein or resulting from its usage. Any usage of the

representations should be reviewed by local professionals to ensure conformance with local and state codes and be field verified prior to the start of any construction.

or any other similar or related documents. All drawings are artist's

data, and specifications provided by Epcon Foundation DG. Higharc,

Inc. is not responsible, nor may it be held liable for any errors or